McDAVID ENGINEERING MECHANICAL & ELECTRICAL ENGINEERING CONSULTANTS

HARRISONBURG, VIRGINIA 22801 e-mail: fred@fastaz.net

JOHN J. BURGER, P.C ARCHITECT FREDERICKSBURG, VIRGINIA

RETAIL FACILITY

ST LADY'S CENTRE RETAIL

KING GEORGE COUNTY, VIRGINIA

SHEEL HILE:
IGHTING PLAN
AND FIXTURE
SCHEDULE


EVISIONS:

DATE: 24 MAY 06

JOB NO.: 0607

SHEET NO.:

E-214 OF 14 SHEETS

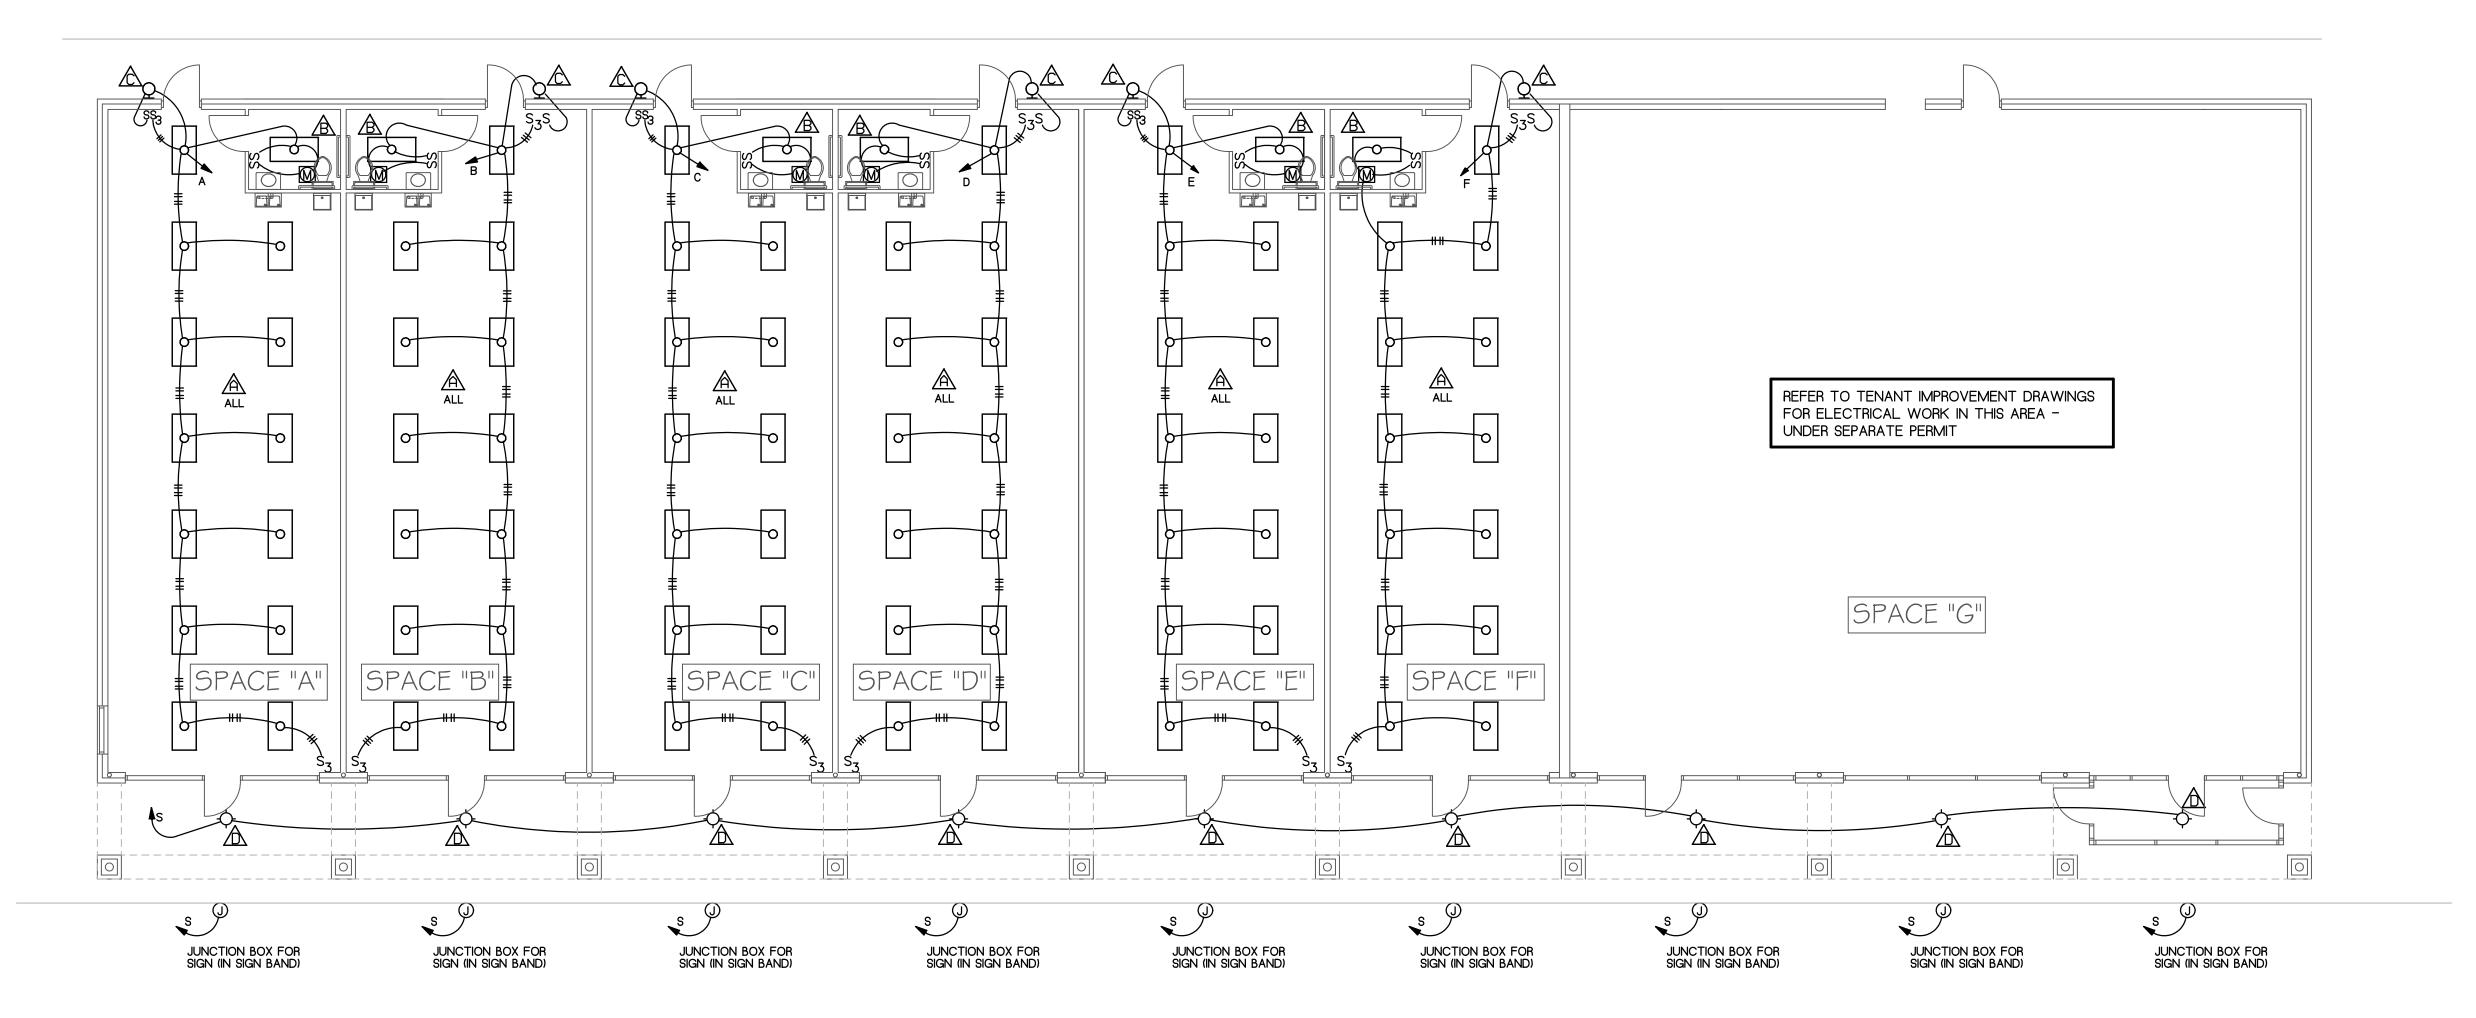

LIGHTING FLOOR PLAN SCALE: 1/8" = 1' - 0"

LIGHTING FIXTURE SCHEDULE							
TYPE	DESCRIPTION	MOUNTING	VOLTS	No.	LAMPS TYPE	MFR - MODEL	REMARKS
A	STATIC TROFFER - 2 x 4 w/ 0.12125" THICK K-12 LENS	RECESSED	120	4	F32-T8-IS	LITHONIA 2GT8-432-A12125-120-GEB	
A	STATIC TROFFER - 2 x 4 w/ 0.12125" THICK K-12 LENS	RECESSED	120	2	F32-T8-IS	LITHONIA 2GT8-232-A12125-120-GEB	
A	WALL BRACKET - SCONCE - EYELID	SURFACE	120	1	42W TRT	LITHONIA VGR2-42TRT-120-DWHG-LPI	
\triangle	DOWNLIGHT	RECESSED	120	2	42 W TRT	LITHONIA AF-2/42TRT-10-CB-120	